
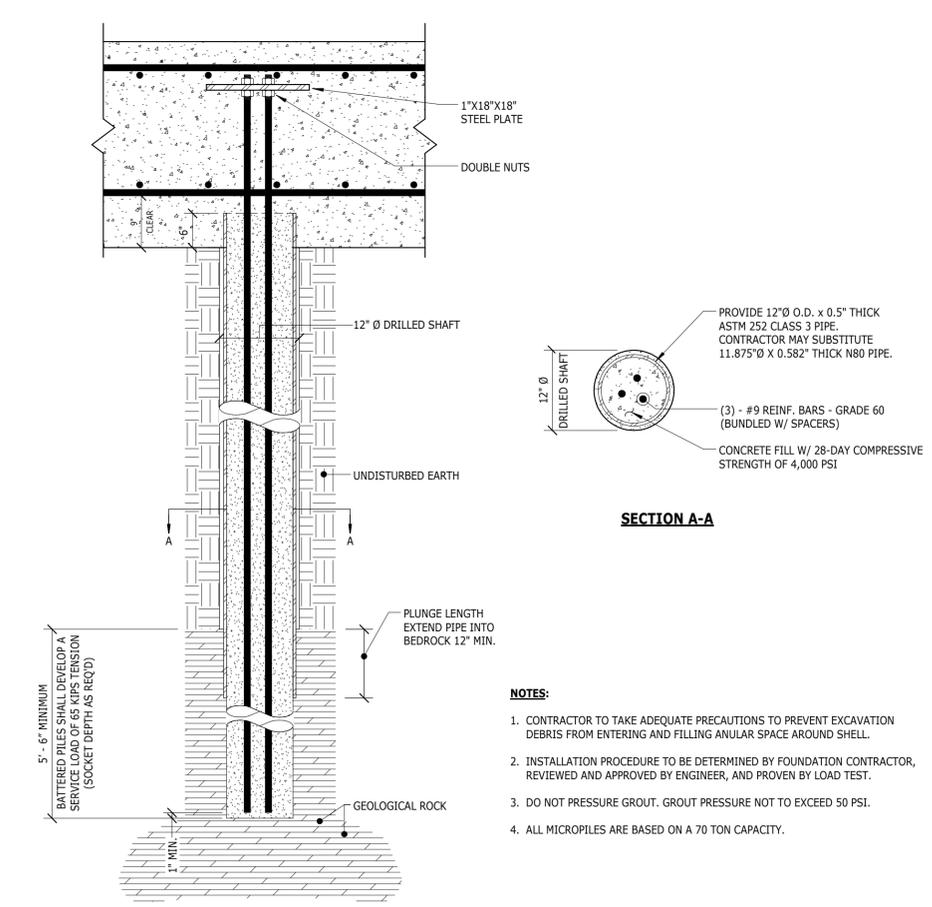
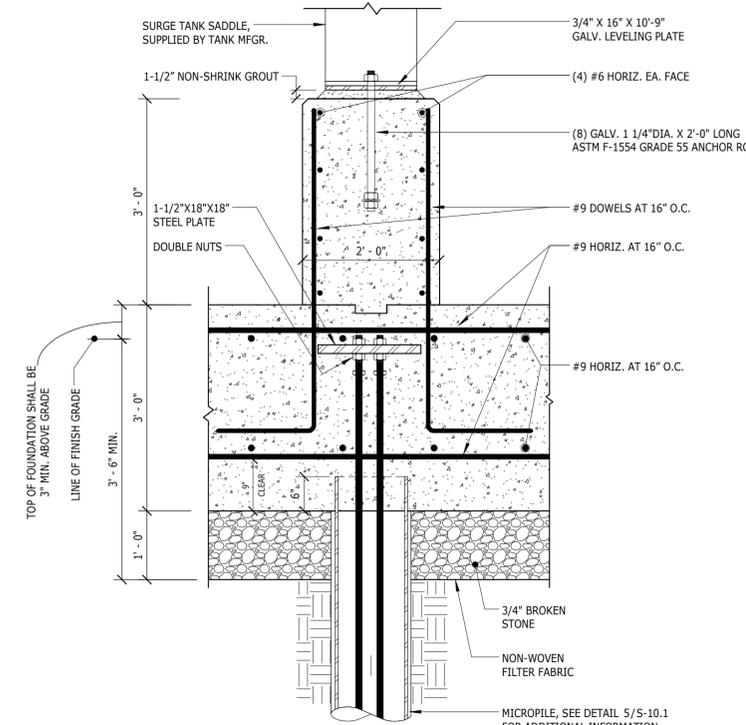
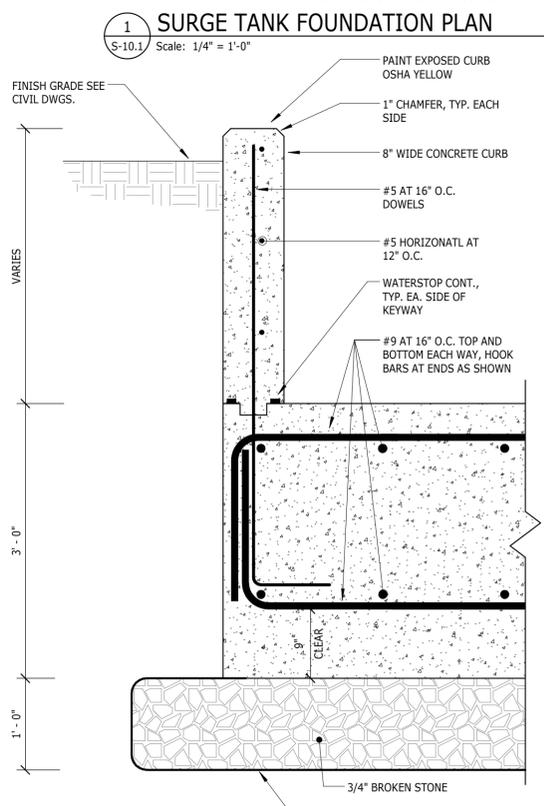
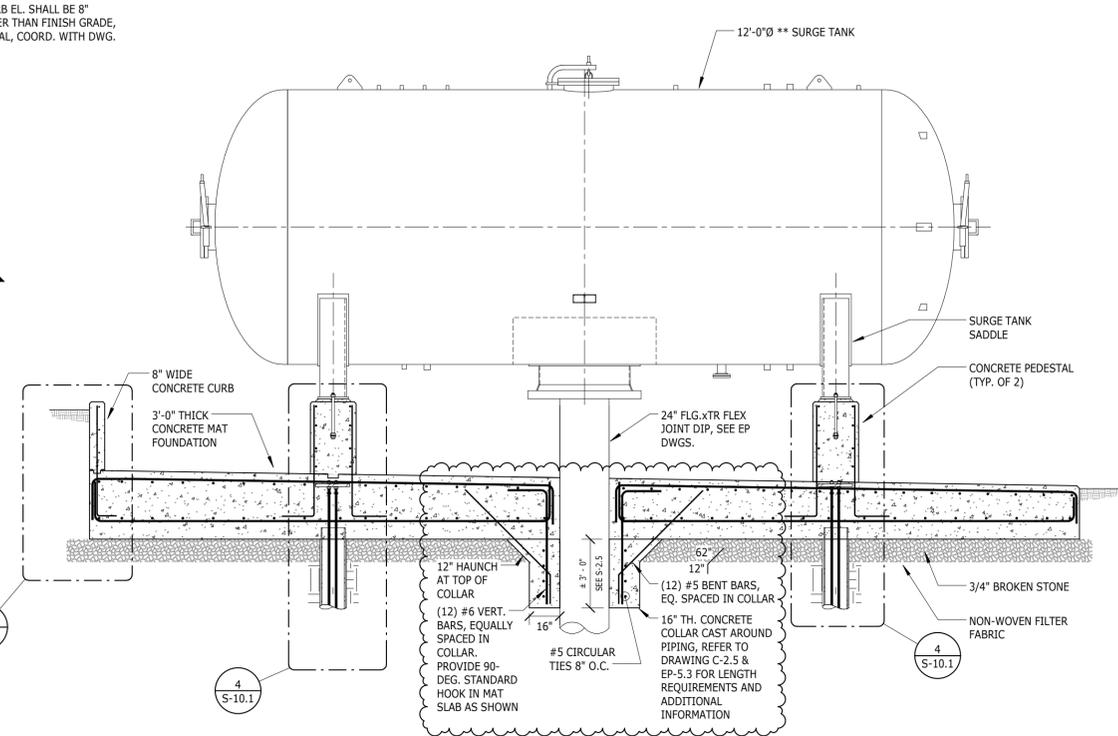


REVISIONS		
Number	Description	Date
1	ADDRESS DEEP REVIEW	5/6/2016
2	BID ADDENDUM 3	7/19/2016
3	BID ADDENDUM 4	8/4/2016

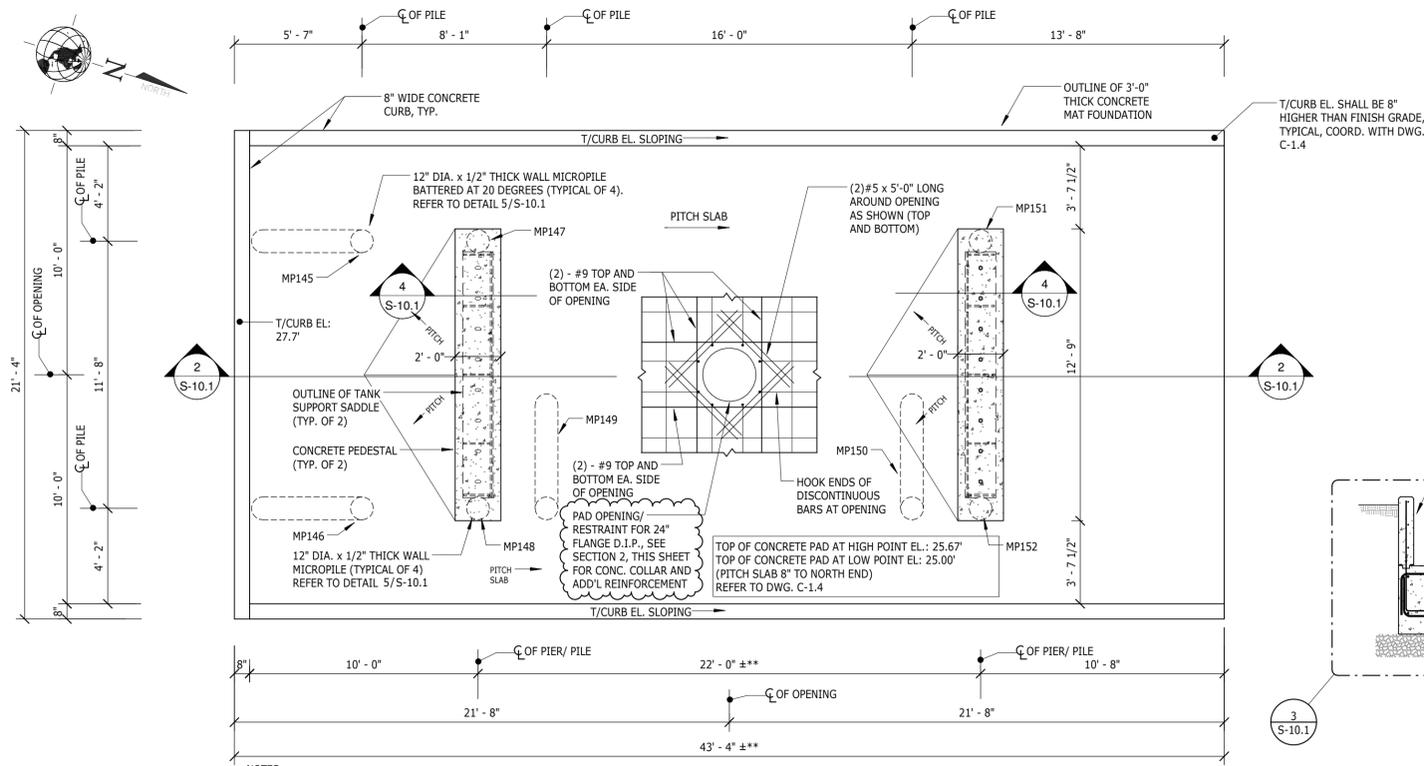

FRANCIS T. PATNAUDE
INTER-MUNICIPAL PUMPING STATION
MIDDLETOWN, CT

SURGE TANK FOUNDATION PLAN & DETAILS

PROJECT NUMBER: 14712.02
DESIGNED BY: IES
DRAWN BY: IES
DATE: FEBRUARY 23, 2016

SHEET NUMBER:

S-10.1